


INSTRUMENT SYMBOLS



HIGH PRESSURE SWITCH



LOW PRESSURE SWITCH

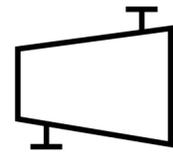

PUMP



MOTOR



MEMBRANE

VALVE SYMBOLS




SOLENOID



CHECK VALVE



FLOW RESTRICTOR

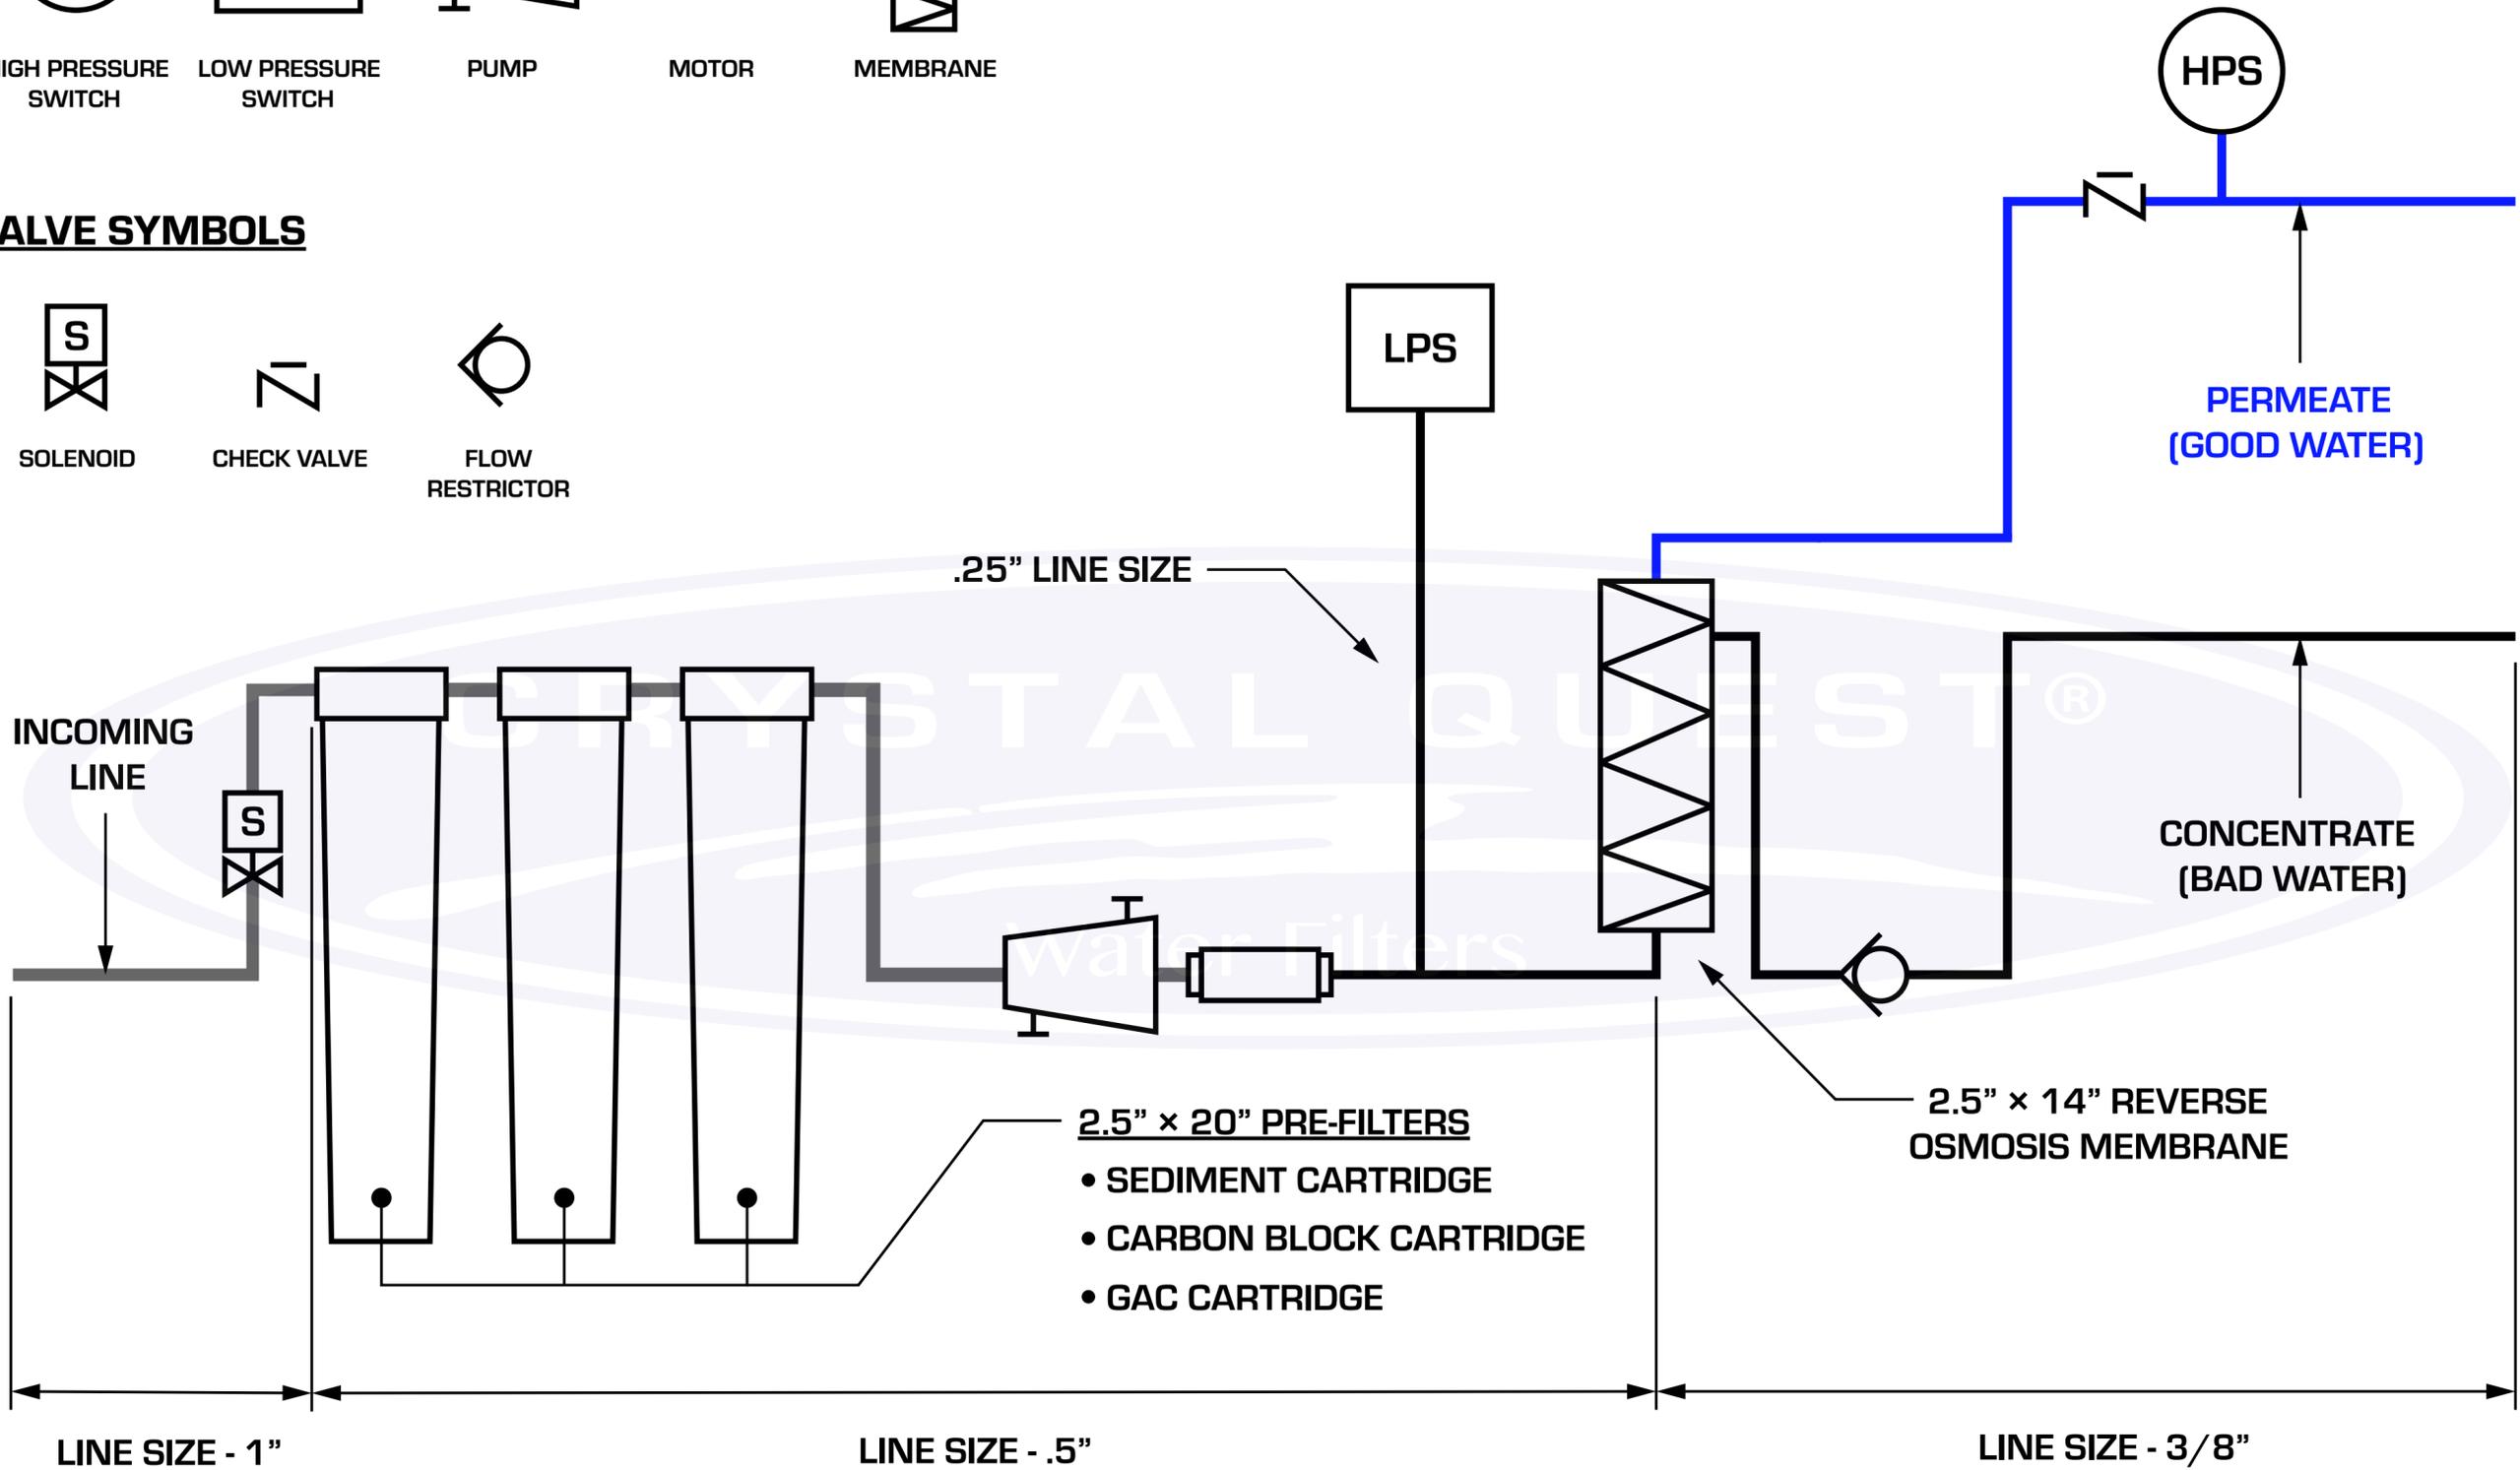

COMMENTS:	UNLESS OTHERWISE SPECIFIED:	DATE: 04/23/2018 DRAWN: DUSTIN	
	DIMENSIONS ARE IN INCHES DRAWING IS NOT TO SCALE	TITLE: 200 GPD REVERSE OSMOSIS P&ID DRAWING	
THE INFORMATION CONTAINED IN THIS DRAWING IS THE SOLE PROPERTY OF CRYSTAL QUEST. ANY REPRODUCTION IN PART OR AS A WHOLE WITHOUT THE WRITTEN PERMISSION OF CRYSTAL QUEST IS STRICTLY PROHIBITED.	DIMENSION KEY:	SIZE	DWG. NO.
	L → LENGTH W → WIDTH H → HEIGHT D → DIAMETER	C	1
		REV #	A
	SCALE: 1:20	WEIGHT:	SHEET 1 OF 1